



ARTISTS IMPRESSION - for illustrative purposes only
(Montville 462 Urban Facade Shown)

NCC 22

The bathroom and powder room must be constructed and reinforced in accordance with NCC regulations. This includes any circulation space req's, noggings and sheeting provisions for future grab rails where required.

PLANS ARE SUBJECT TO LOCAL COUNCIL & DEVELOPERS GUIDELINES (COVENANTS).

MONTVILLE 462

Urban Streetscape

Prestige Series

CONCEPT 18/07/2022

© Copyright Archiman Pty Ltd
exclusive to
G.J. Gardner Homes
Concept plans only,
final working drawings may vary

FLOOR AREAS

LIVING
GARAGE
ALFRESCO
VERANDAH
PORCH

TOTAL 460.0 m²


333.0 m²
57.2 m²
26.7 m²
35.4 m²
7.7 m²

Min. Lot Width
44 m +

ARTIST IMPRESSION
N.T.S.

G.J. Gardner.


HOMES

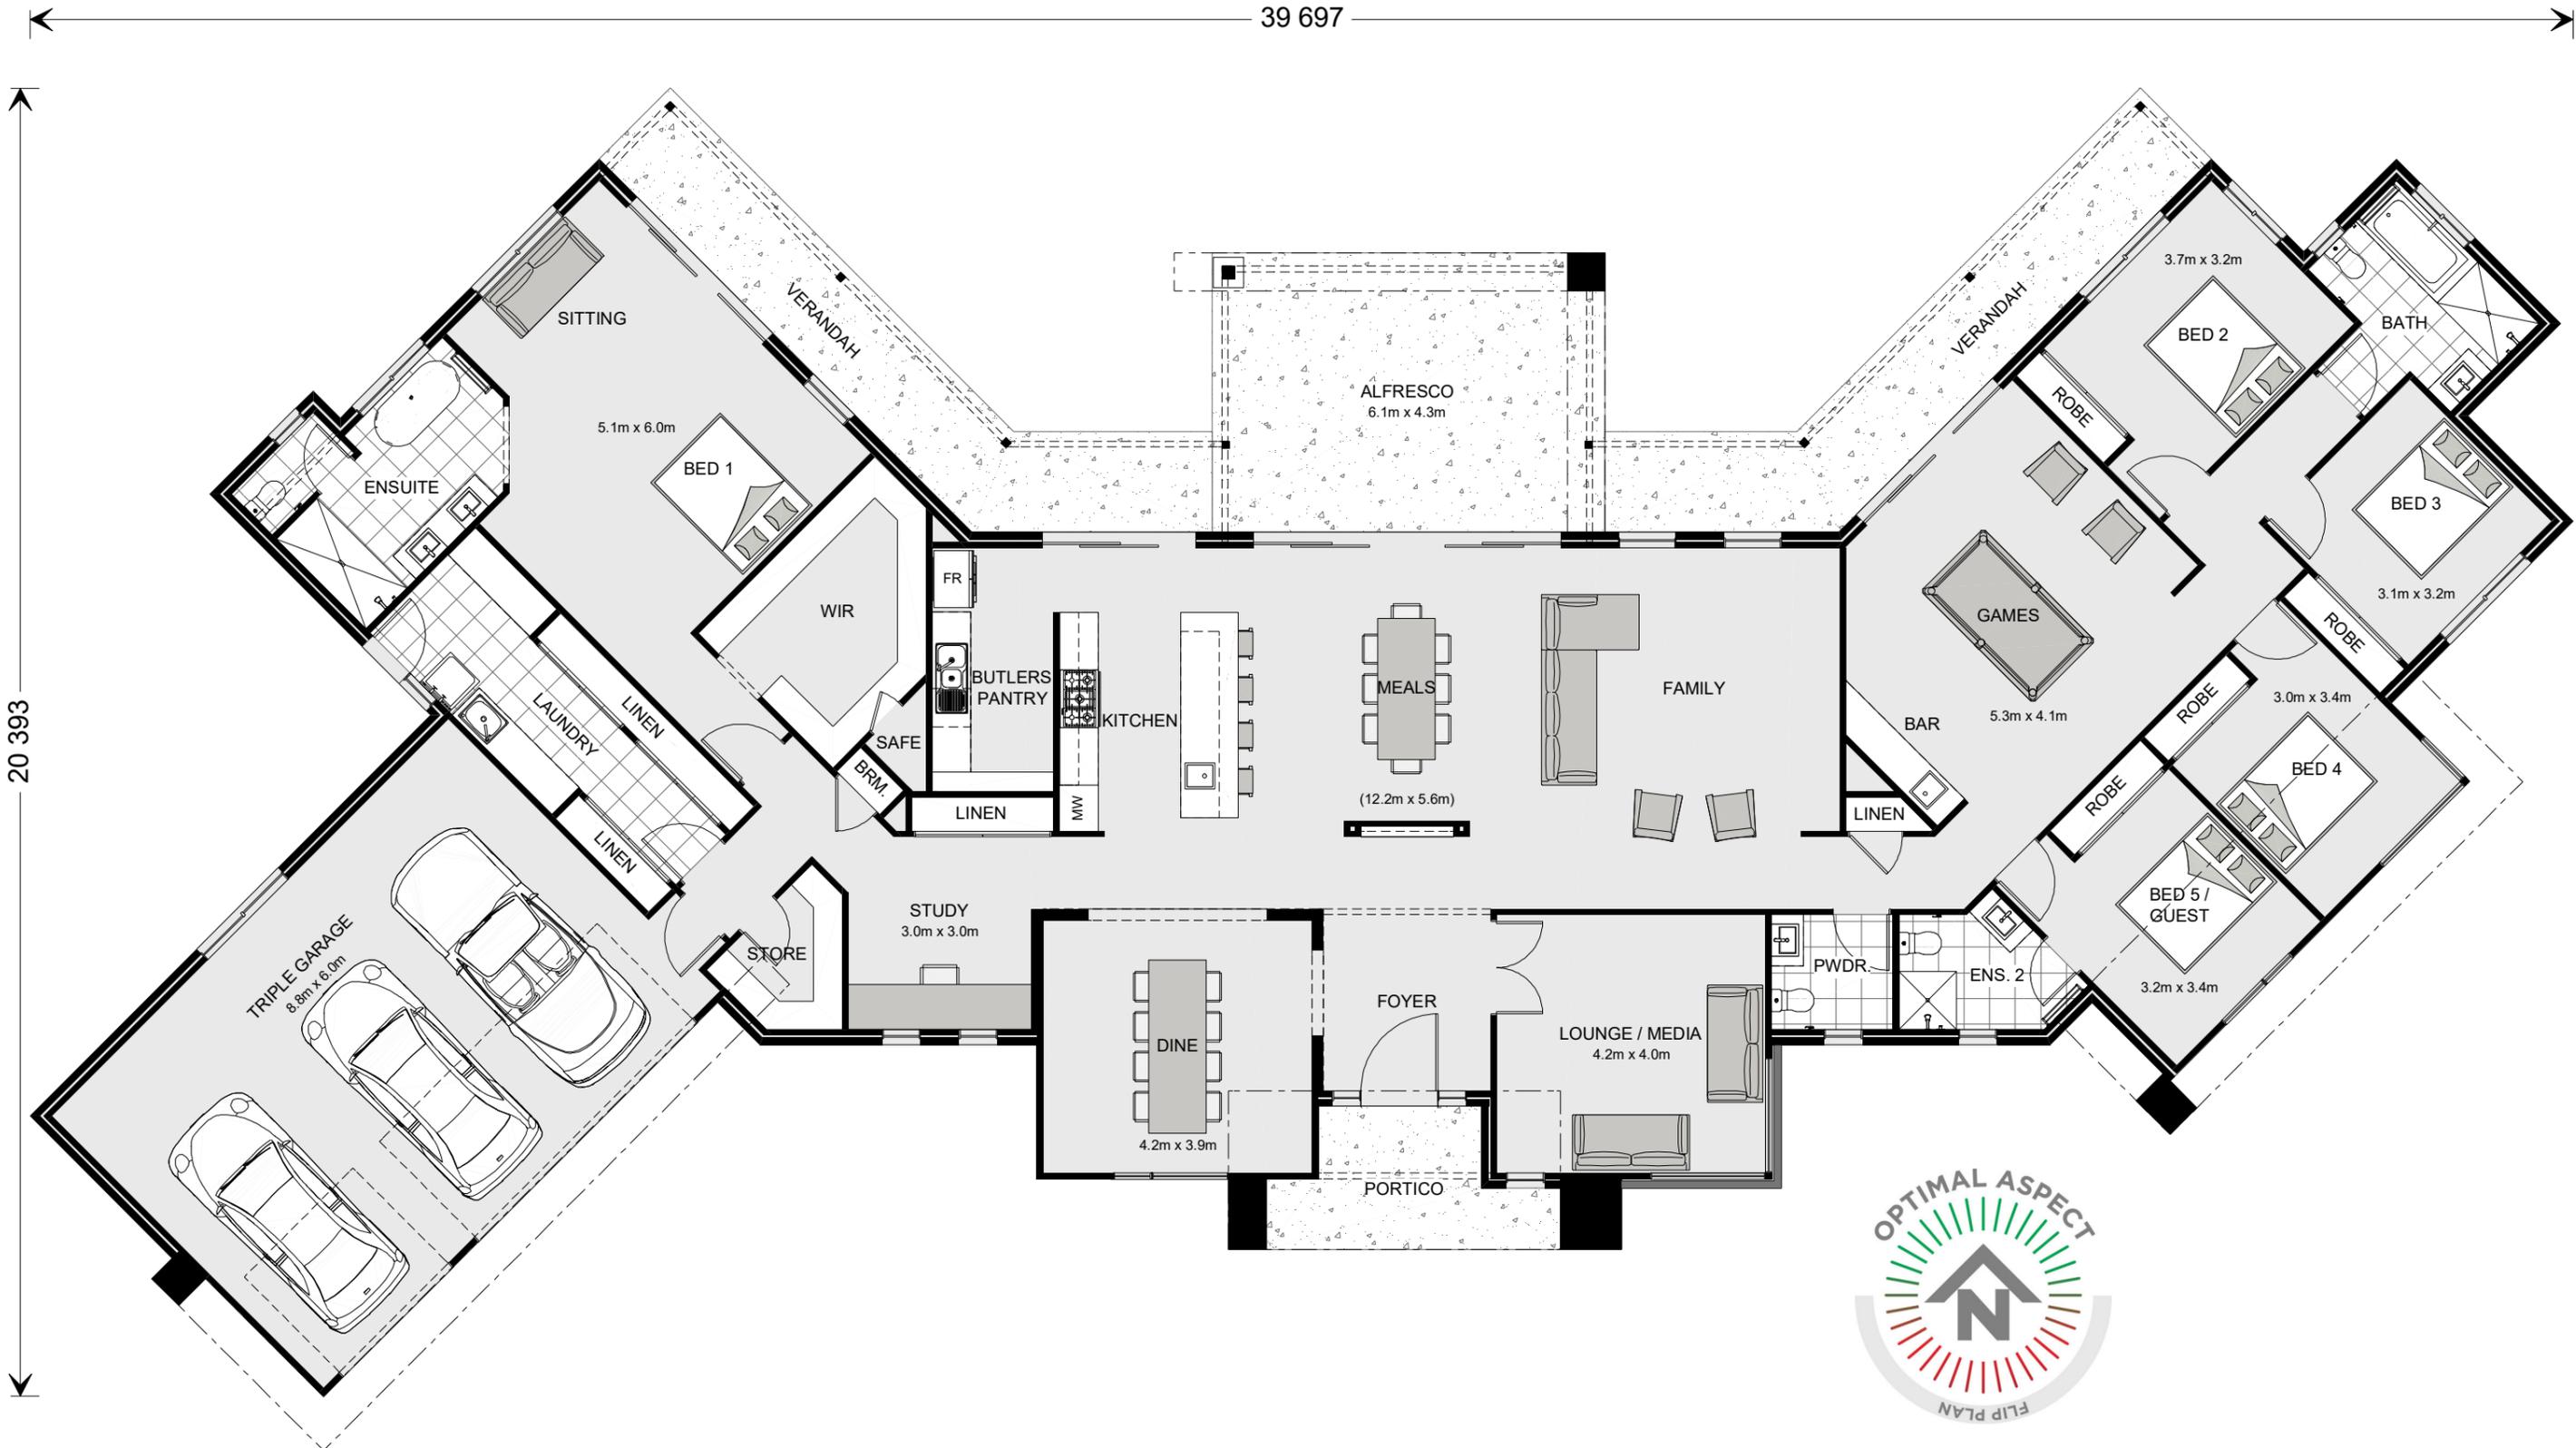

NCC 22 The bathroom and powder room must be constructed and reinforced in accordance with NCC regulations. This includes any circulation space req's, noggings and sheeting provisions for future grab rails where required.

PLANS ARE SUBJECT TO LOCAL COUNCIL & DEVELOPERS GUIDELINES (COVENANTS).

MONTVILLE 462 Urban Streetscape Prestige Series	CONCEPT 18/07/2022 © Copyright Archiman Pty Ltd exclusive to G.J. Gardner Homes Concept plans only, final working drawings may vary	FLOOR AREAS LIVING 333.0 m ² GARAGE 57.2 m ² ALFRESCO 26.7 m ² VERANDAH 35.4 m ² PORCH 7.7 m ²	TOTAL 460.0 m ²	Min. Lot Width 44 m +	PRESENTATION PLAN Scale 1:100 @A3	G.J. Gardner. HOMES

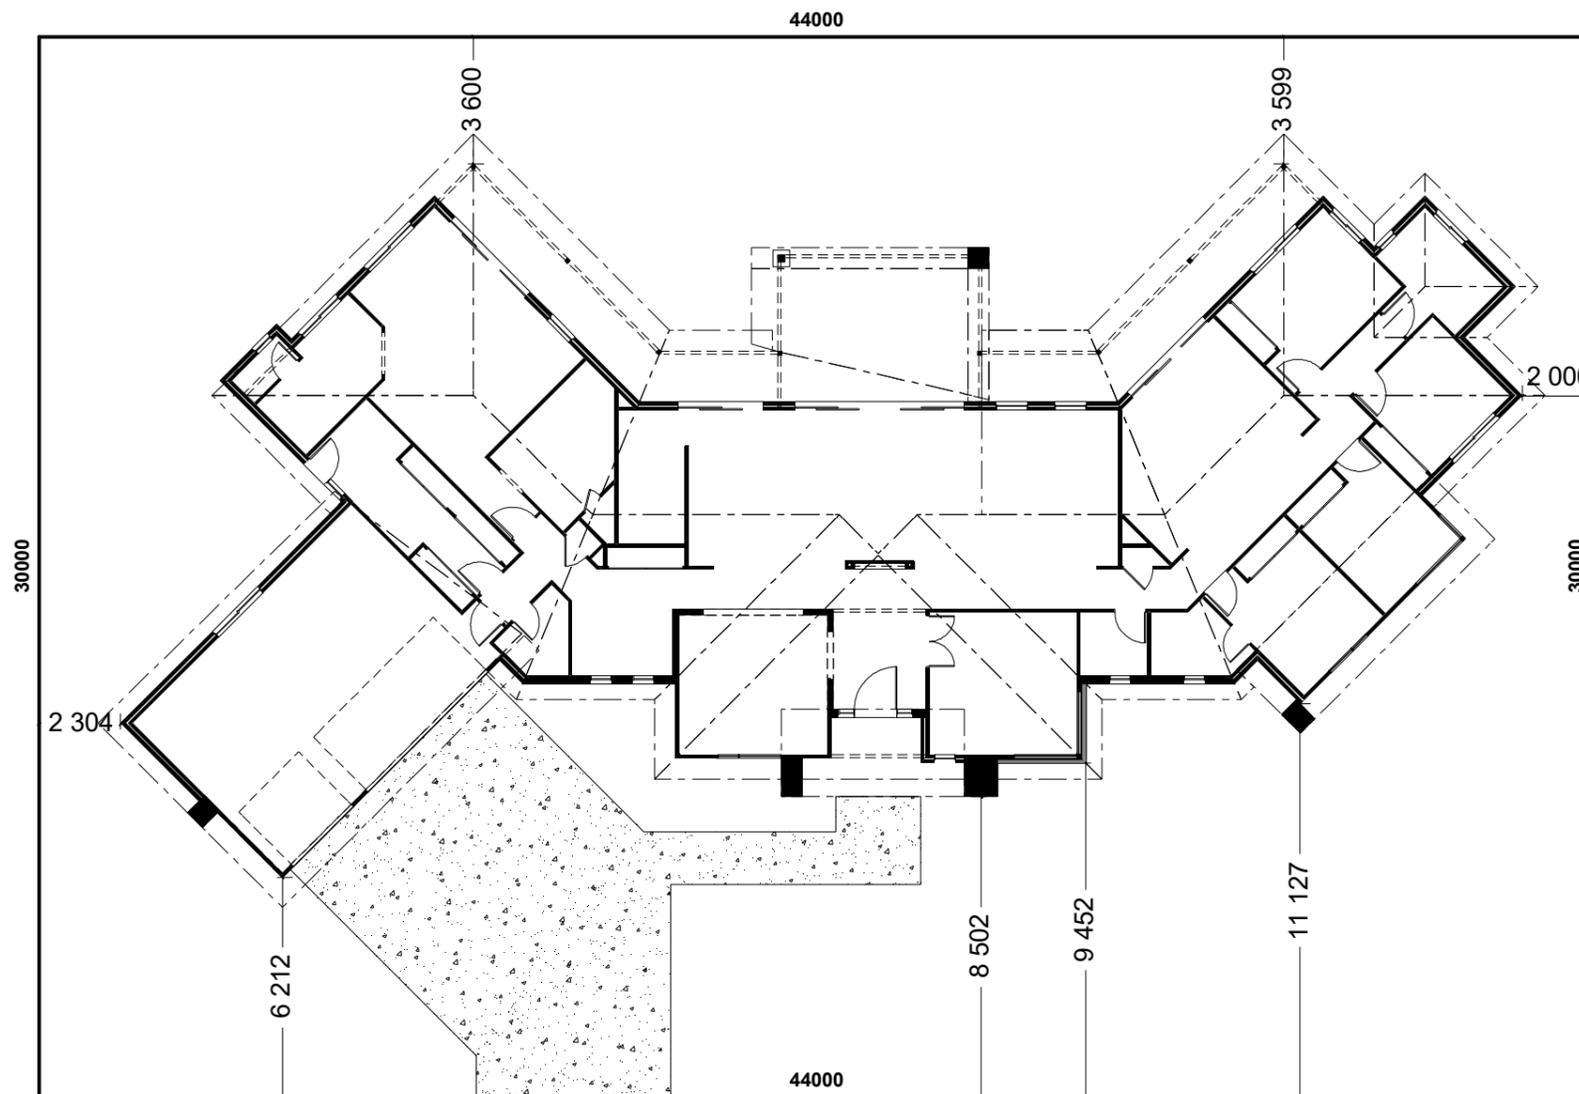

STREET FRONTAGE

INDICATIVE SITE PLAN ONLY. ACTUAL LOT WIDTH, SIZE AND SETBACKS MAY VARY TO SUIT LOCAL REQUIREMENT'S AND MAY REQUIRE A LARGER SITE OR PLAN MODIFICATIONS TO SUIT A PARTICULAR SITE.

NCC 22

The bathroom and powder room must be constructed and reinforced in accordance with NCC regulations. This includes any circulation space req's, noggings and sheeting provisions for future grab rails where required.

PLANS ARE SUBJECT TO LOCAL COUNCIL & DEVELOPERS GUIDELINES (COVENANTS).

MONTVILLE 462

Urban Streetscape

Prestige Series

CONCEPT 18/07/2022
 © Copyright Archiman Pty Ltd
 exclusive to
 G.J. Gardner Homes
 Concept plans only,
 final working drawings may vary


FLOOR AREAS	TOTAL 460.0 m ²
LIVING	333.0 m ²
GARAGE	57.2 m ²
ALFRESCO	26.7 m ²
VERANDAH	35.4 m ²
PORCH	7.7 m ²

Min. Lot Width
44 m +

SITE PLAN
Scale 1:200 @A3

G.J. Gardner.


HOMES

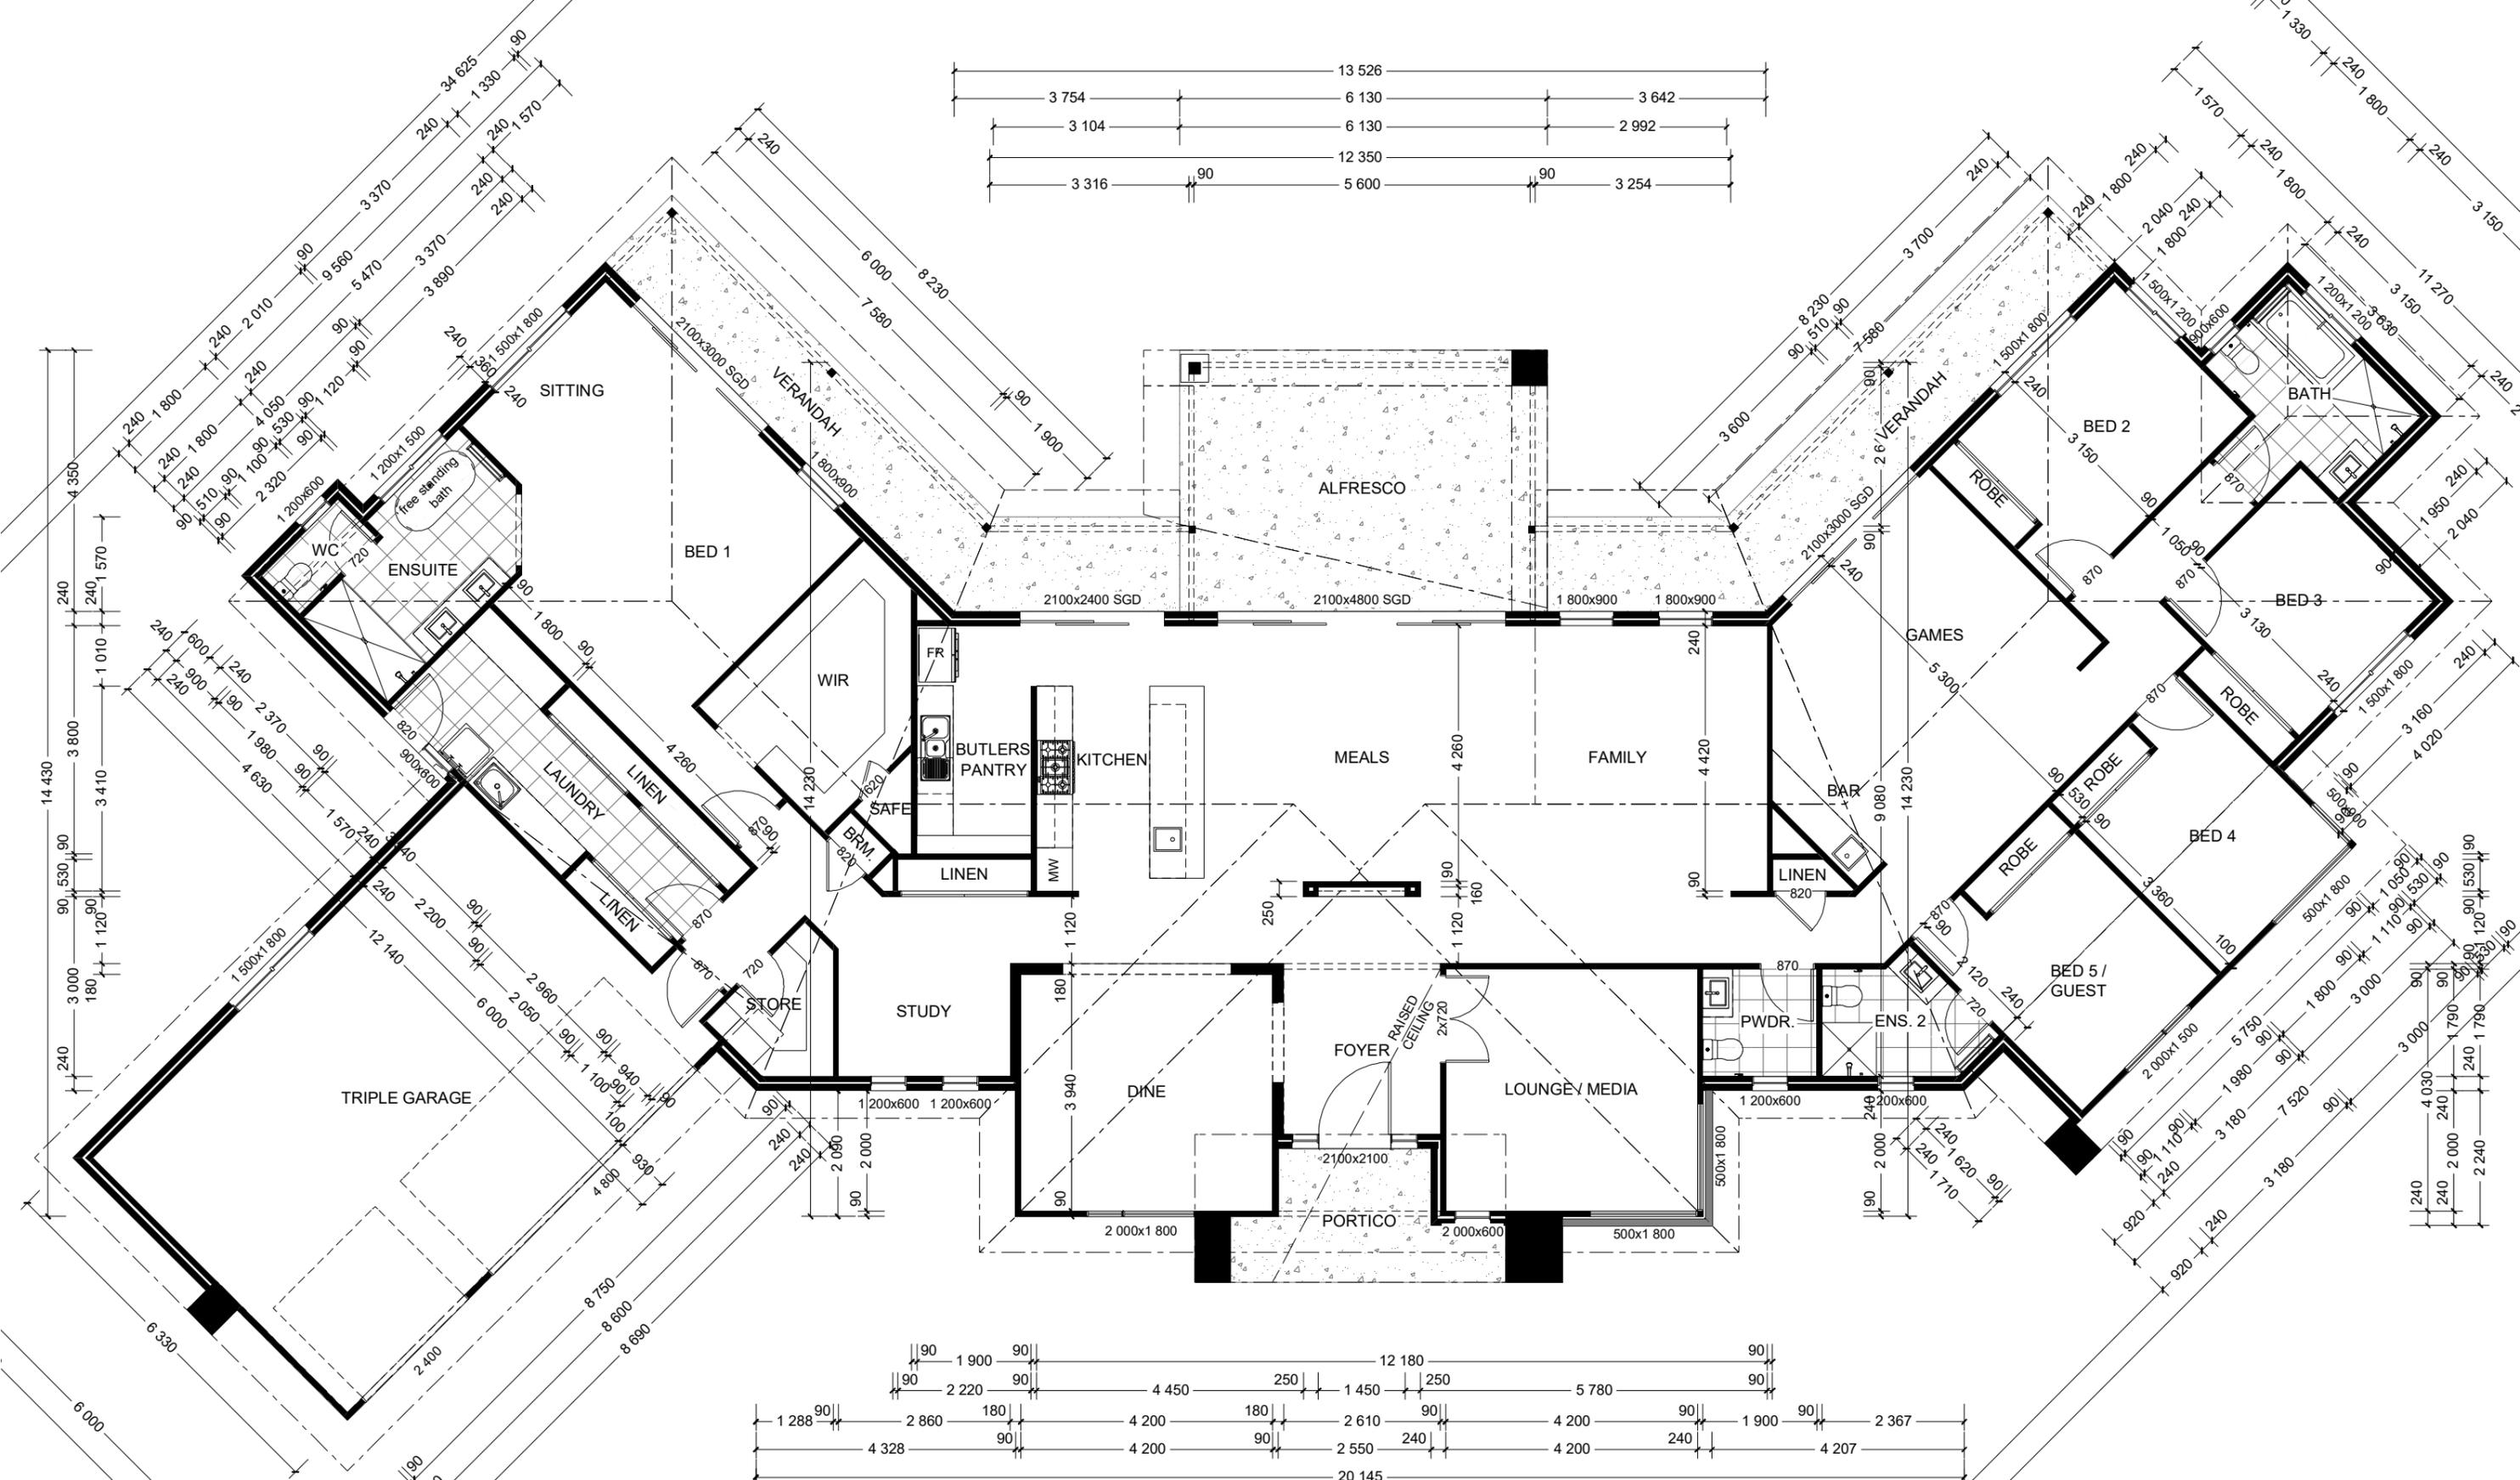

NCC 22 The bathroom and powder room must be constructed and reinforced in accordance with NCC regulations. This includes any circulation space req's, noggings and sheeting provisions for future grab rails where required.

PLANS ARE SUBJECT TO LOCAL COUNCIL & DEVELOPERS GUIDELINES (COVENANTS).

MONTVILLE 462 Urban Streetscape Prestige Series	CONCEPT 18/07/2022 © Copyright Archiman Pty Ltd exclusive to G.J. Gardner Homes Concept plans only, final working drawings may vary	FLOOR AREAS LIVING 333.0 m ² GARAGE 57.2 m ² ALFRESCO 26.7 m ² VERANDAH 35.4 m ² PORCH 7.7 m ²	TOTAL 460.0 m ²	Min. Lot Width 44 m +	FLOOR PLAN Scale 1:100 @A3	G.J. Gardner. HOMES

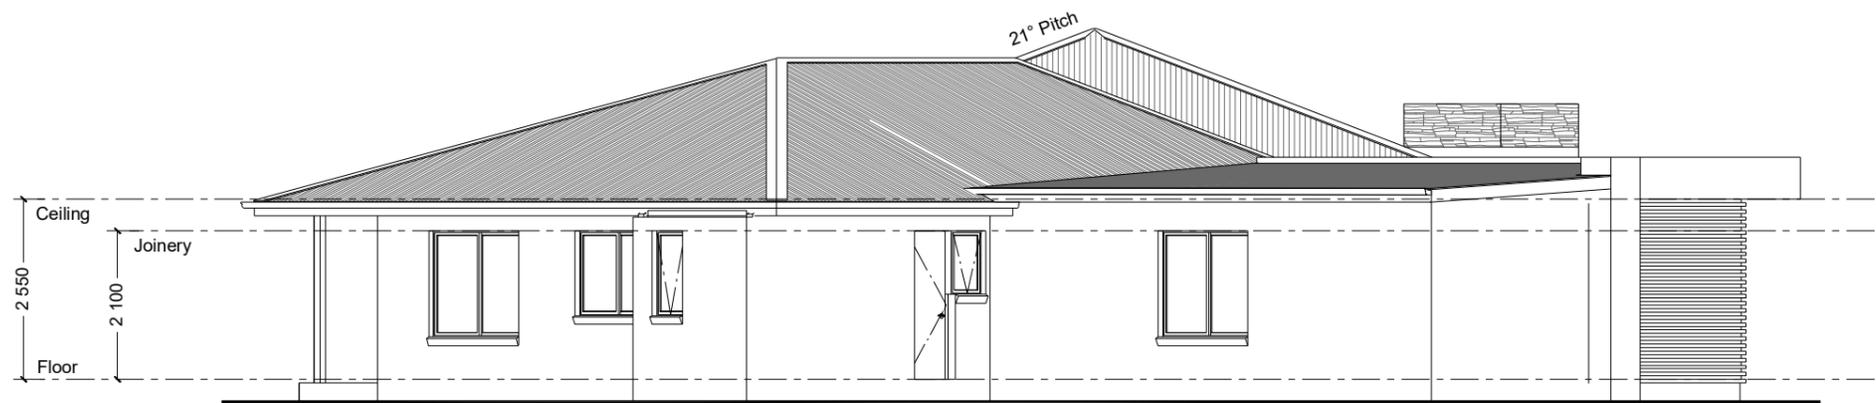

NCC 22

The bathroom and powder room must be constructed and reinforced in accordance with NCC regulations. This includes any circulation space req's, noggings and sheeting provisions for future grab rails where required.

PLANS ARE SUBJECT TO LOCAL COUNCIL & DEVELOPERS GUIDELINES (COVENANTS).

MONTVILLE 462

Urban Streetscape

Prestige Series

CONCEPT 18/07/2022

© Copyright Archiman Pty Ltd
exclusive to
G.J. Gardner Homes
Concept plans only,
final working drawings may vary

FLOOR AREAS

LIVING	333.0 m ²
GARAGE	57.2 m ²
ALFRESCO	26.7 m ²
VERANDAH	35.4 m ²
PORCH	7.7 m ²


TOTAL 460.0 m²

Min. Lot Width
44 m +

ELEVATIONS
Scale 1:100 @A3

G.J. Gardner.

HOMES

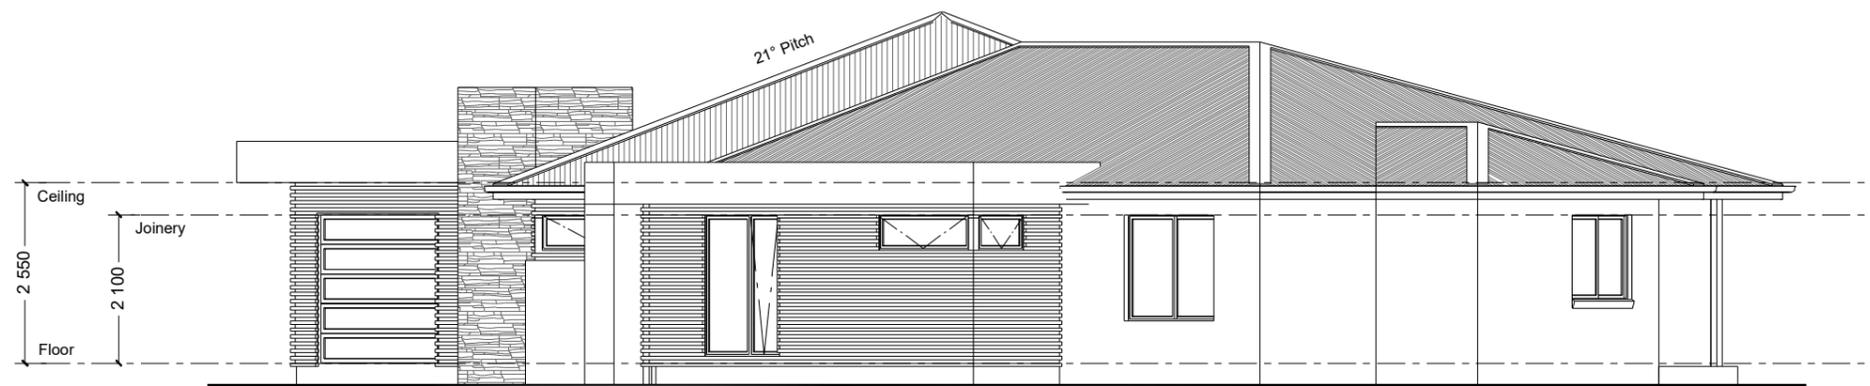

NCC 22

The bathroom and powder room must be constructed and reinforced in accordance with NCC regulations. This includes any circulation space req's, noggings and sheeting provisions for future grab rails where required.

PLANS ARE SUBJECT TO LOCAL COUNCIL & DEVELOPERS GUIDELINES (COVENANTS).

MONTVILLE 462

Urban Streetscape

Prestige Series

CONCEPT 18/07/2022

© Copyright Archiman Pty Ltd
exclusive to
G.J. Gardner Homes
Concept plans only,
final working drawings may vary

FLOOR AREAS TOTAL 460.0 m²

LIVING	333.0 m ²
GARAGE	57.2 m ²
ALFRESCO	26.7 m ²
VERANDAH	35.4 m ²
PORCH	7.7 m ²

Min. Lot Width
44 m +


ELEVATIONS
Scale 1:100 @A3

G.J. Gardner.

HOMES

ELECTRICAL LEGEND

NOTE:
ALL ELECTRICAL WORK MUST
BE COMPLETED TO THE
RELEVANT AUSTRALIAN
STANDARDS AND THE
NATIONAL CONSTRUCTION
CODE OF AUSTRALIA.

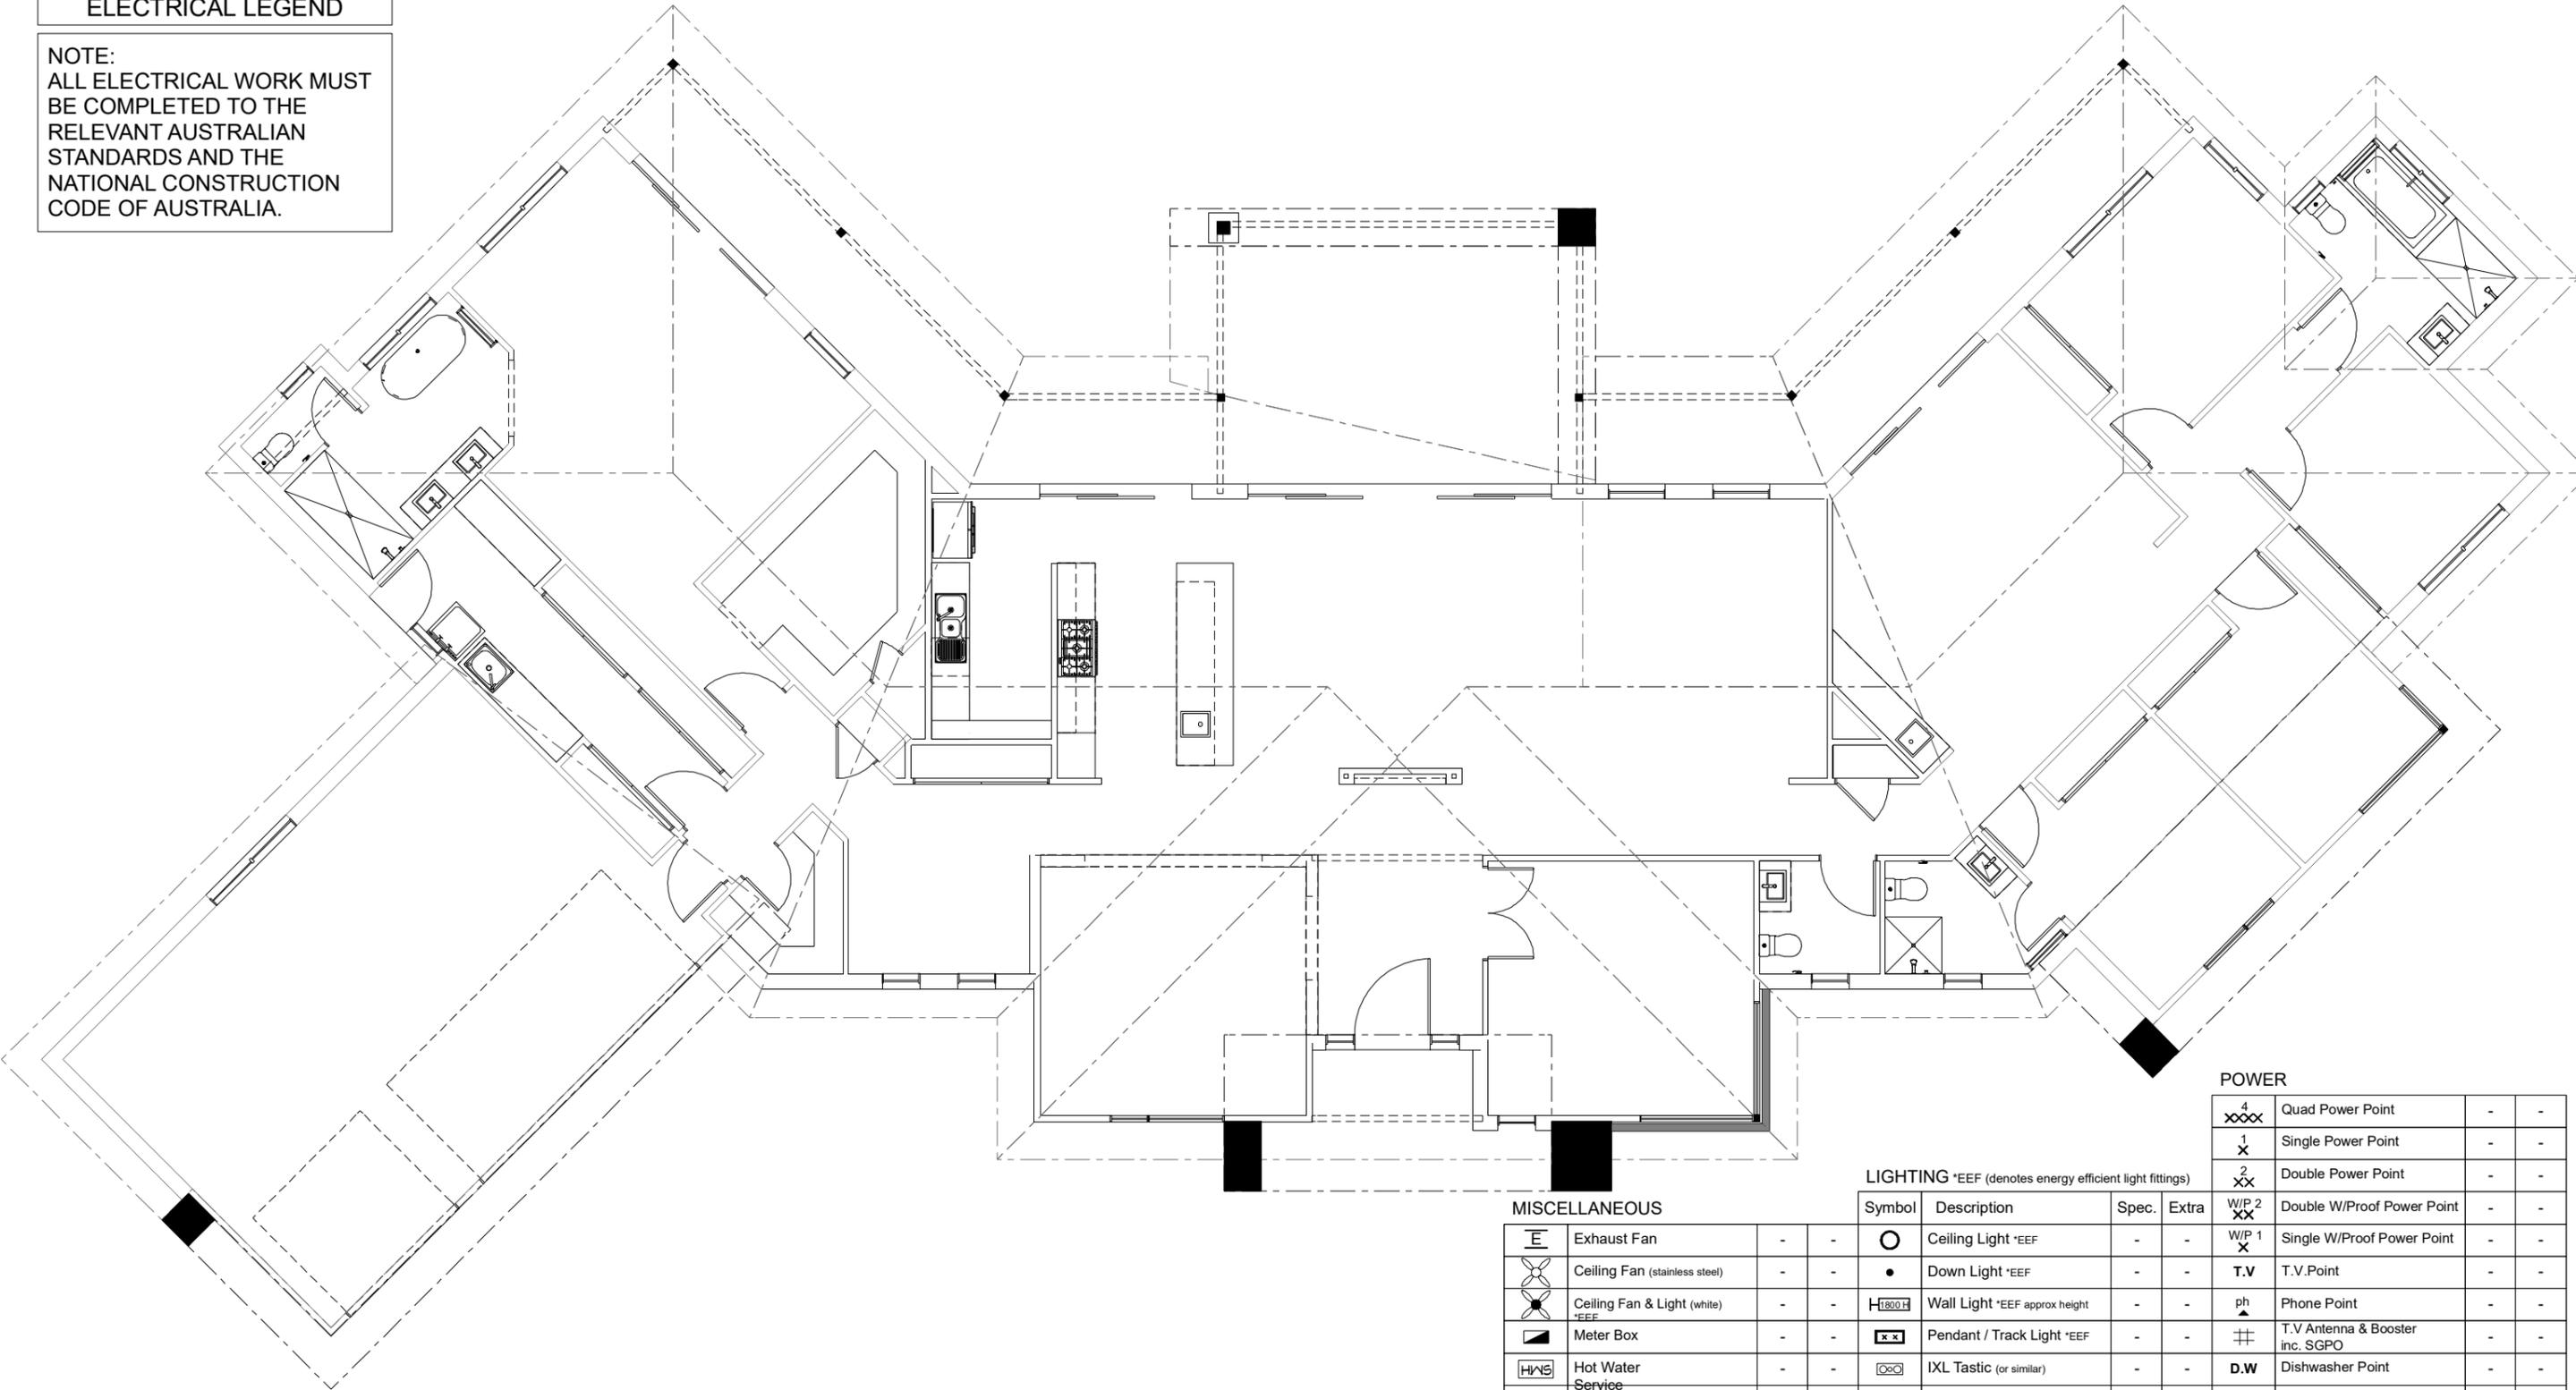

POWER

4 XXXX	Quad Power Point	-	-
1 X	Single Power Point	-	-
2 XX	Double Power Point	-	-
W/P 2 XX	Double W/Proof Power Point	-	-
W/P 1 X	Single W/Proof Power Point	-	-
T.V	T.V.Point	-	-
ph	Phone Point	-	-
⚡	T.V Antenna & Booster inc. SGPO	-	-
D.W	Dishwasher Point	-	-
R.H	Rangehood Point	-	-
M.W	Microwave Point	-	-
O.V	Oven Point	-	-
C.T	Cook Top Iso point	-	-

LIGHTING *EEF (denotes energy efficient light fittings)

MISCELLANEOUS

Symbol	Description	Spec.	Extra	Symbol	Description	Spec.	Extra
⊞	Exhaust Fan	-	-	○	Ceiling Light *EEF	-	-
⊞	Ceiling Fan (stainless steel)	-	-	●	Down Light *EEF	-	-
⊞	Ceiling Fan & Light (white) *EEF	-	-	⊞	Wall Light *EEF approx height	-	-
⊞	Meter Box	-	-	⊞	Pendant / Track Light *EEF	-	-
HWS	Hot Water Service	-	-	⊞	IXL Tastic (or similar)	-	-
SA	Smoke Detectors	-	-	⊞	Batten Fluoro Light *EEF	-	-
ds	Dimmer Switch	-	-	⊞	Round Fluoro Light *EEF	-	-
2 way	Two Way Switch	-	-	⊞	Flood / Spot Light *EEF	-	-
AC	A/C Condensor Iso Point	-	-	TOTAL LIGHT POINTS			

NCC 22

The bathroom and powder room must be constructed and reinforced in accordance with NCC regulations. This includes any circulation space req's, noggings and sheeting provisions for future grab rails where required.

PLANS ARE SUBJECT TO LOCAL COUNCIL & DEVELOPERS GUIDELINES (COVENANTS).

MONTVILLE 462

Urban Streetscape

Prestige Series

CONCEPT 18/07/2022

© Copyright Archiman Pty Ltd
exclusive to
G.J. Gardner Homes
Concept plans only,
final working drawings may vary

FLOOR AREAS TOTAL 460.0 m²

LIVING	333.0 m ²
GARAGE	57.2 m ²
ALFRESCO	26.7 m ²
VERANDAH	35.4 m ²
PORCH	7.7 m ²

Min. Lot Width
44 m +

ELECTRICAL PLAN
Scale 1:100 @A3

G.J. Gardner.

HOMES